

PROJECT

PROPOSED INTERIOR FURNISHING
WORK FOR
INDIAN BANK
AT
MILLERPURAM BRANCH
(TRIUNELVELI ZONE)

NOTE

- 1) ALL DIMENSIONS ARE IN FEET & INCHES
- 2) DRAWING TO BE READ IN CONJUNCTION WITH DETAILS
- 3) ALL DISCREPANCIES MUST BE BROUGHT TO THE NOTICE OF THE ARCHITECT.

LEGENDS

	BOX TYPE FITTING 1X36W (WALL)
	BOX TYPE FITTING 1X36W (CEILING)
	CEILING FAN
	WALL MOUNTED FAN 16\"/>
	12\"/>
	2/2 MIRROR OPTICAL
	DISTRIBUTION BOARD
	UPS DB
	MAIN PANNEL
	CEILING LIGHT
	4 NOS 6A PLUG SOCKET (UPS)

AREA DETAILING:

SAFE ROOM	252.50 SQ.FT
RECORD/DINING ROOM	303.00 SQ.FT
BANKING HALL	837.00 SQ.FT
ATM	80.00 SQ.FT
TOTAL AREA	1472.50 SQ.FT

FALSE CEILING AREA

BANKING HALL	837.00 SQ.FT
ATM	80.00 SQ.FT
TOTAL AREA	917.00 SQ.FT

TITLE

ELECTRICAL LAYOUT



DRAWN : Ar.Vivek

SCALE : 1"=1'3"

JOB NO: -112- 2024

DATE : 28.05.2025

SHEET SIZE: A4

ARCHITECT

Ar. T.MAYILVAHANAN, M.E., A.I.I.A., M.C.A., P.h.d.,




COS CONSULTANCY SERVICES

ARCHITECTURE, INTERIORS, STRUCTURAL
ENGINEERS & DESIGNERS

6/13, Kamaraj Nagar 4th Street,
Tallakulam, Madurai - 625002

Phone : 0452 - 2521869

Email id: cosquant93@gmail.com

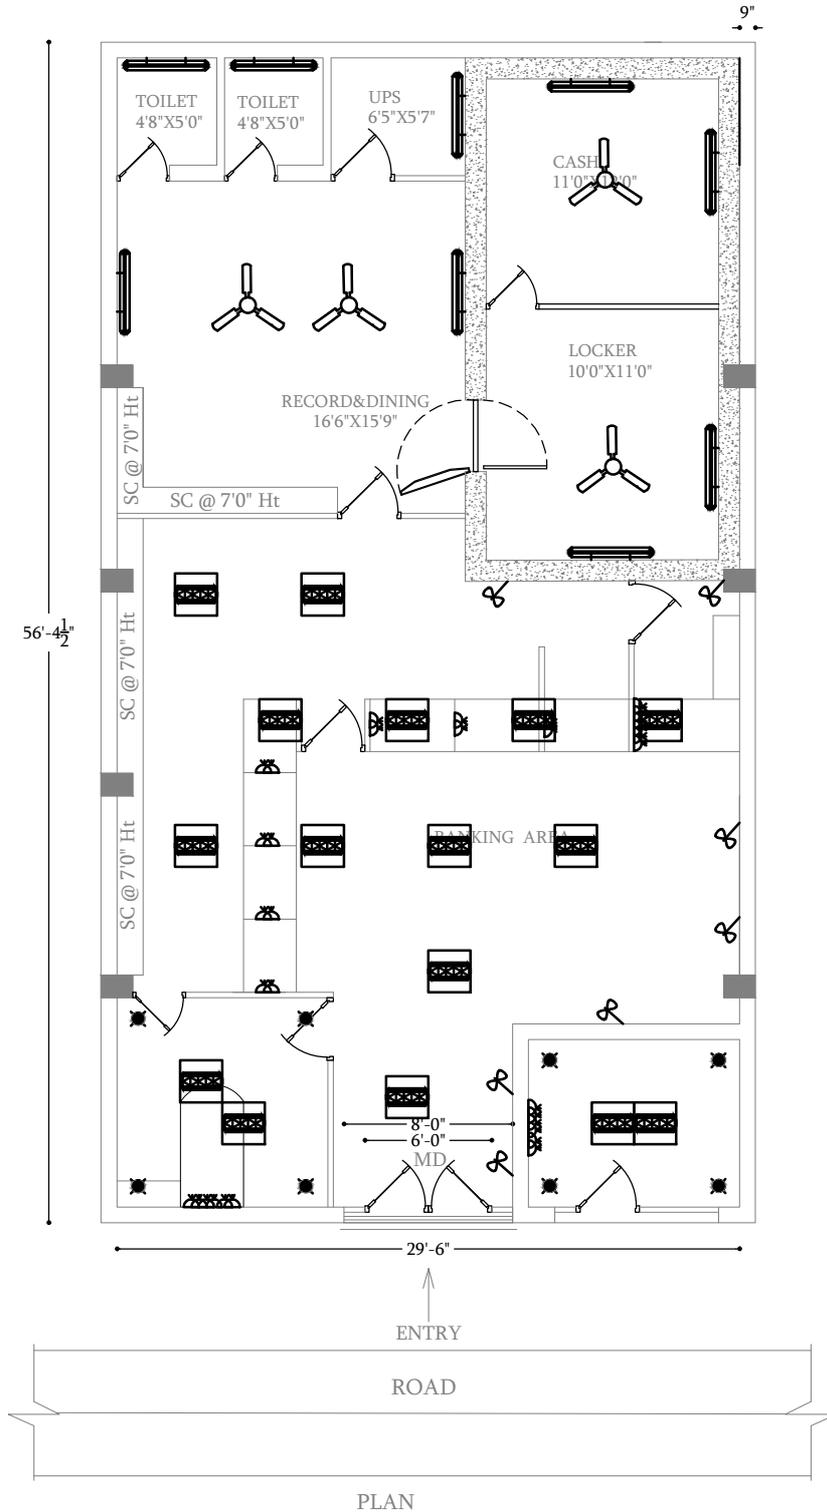

PLAN